


LIGHTING FIXTURE SCHEDULE					
TYPE	MANUFACTER/DESCRIPTION	VOLTAGE	LAMPS	LOCATION	REMARKS
SL1	LED WALL MOUNTED LUMINAIRE DARK BRONZE FINISH	277		AS SHOWN	1,2

- 1. FIXTURES SHALL BE UL OR ETL LISTED.
- . MOUNTING HARDWARE SUCH AS HANGERS, BRACKETS, RAILS, YOKES, STEMS, CHAINS, ETC., SHALL BE PROVIDED AS NECESSARY TO MOUNT SPECIFIED FIXTURE.

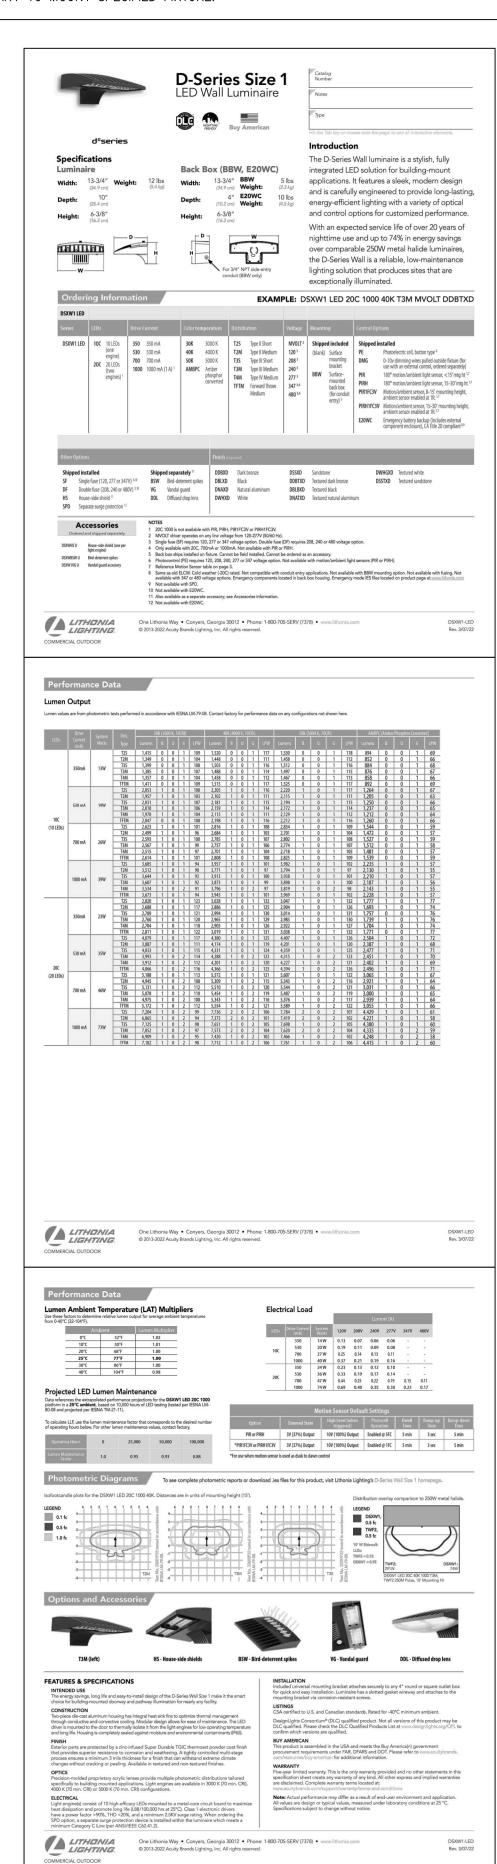

RELATED

1920 Alton Rd. Miami Beach, FL 33139

Gensler

MAIN OFFICE Tel 415.433.3700 45 Fremont Street, Suite 1500 Fax 415.836.4599 San Francisco, CA 94105

SATELLITE OFFICE Tel 305.350.7070 545 N.W. 26th Street, Suite 250 Fax 305.350.7071 Miami, FL 33127

United States

BILZIN SUMBERG

Land Use
1450 Brickell Avenue, 23rd Floor
Miami, FL 33131

United States

Tel 305.350.2355

PRIME GROUP MANAGEMENT, LLC Management Group 3250 NE 1st Ave, Suite 305 Miami, FL 33137 Tel 305.281.7383

KIMLEY HORN
Civil, Landscape, Traffic
8201 Peters Road, Suite 2200
Plantation, FL 33324
Tel 954.535.5144
THORNTON THOMESETTI

Structure 80 SW 8th Street, Suite 2160 Miami, FL 33130 Tel 954.990.0556

CES ENGINEERING
MEPFP
2937 W. Cypress Creek Rd, Suite 102
Fort Lauderdale, FL 33309
Tel 954.990.0556

1 09/06/2022 ISSUE FOR SCHEMATIC DESIGN

Seal / Signature

NOT FOR CONSTRUCTION

Project Name

1920 Alton Road

Project Number

79.0666.000

Description

LIGHTING PLAN - LEVEL 03

Scale

1/8" = 1'-0"

EL-103

