


LIGHTING SCHEDULE

SYMBOL	MANUFACTURER/MODEL/DESCRIPTION	QTY	DETAIL
●	ITEM: 7' AFF POLE LIGHT	8	
●	ITEM: 24" AFF BOLLARD	20	
□	ITEM: WALL MOUNTED LIGHTS BACKYARD	6	
□	ITEM: PLANTER UP LIGHTS	36	
□	ITEM: WALL MOUNTED RECESSED LIGHT	6	

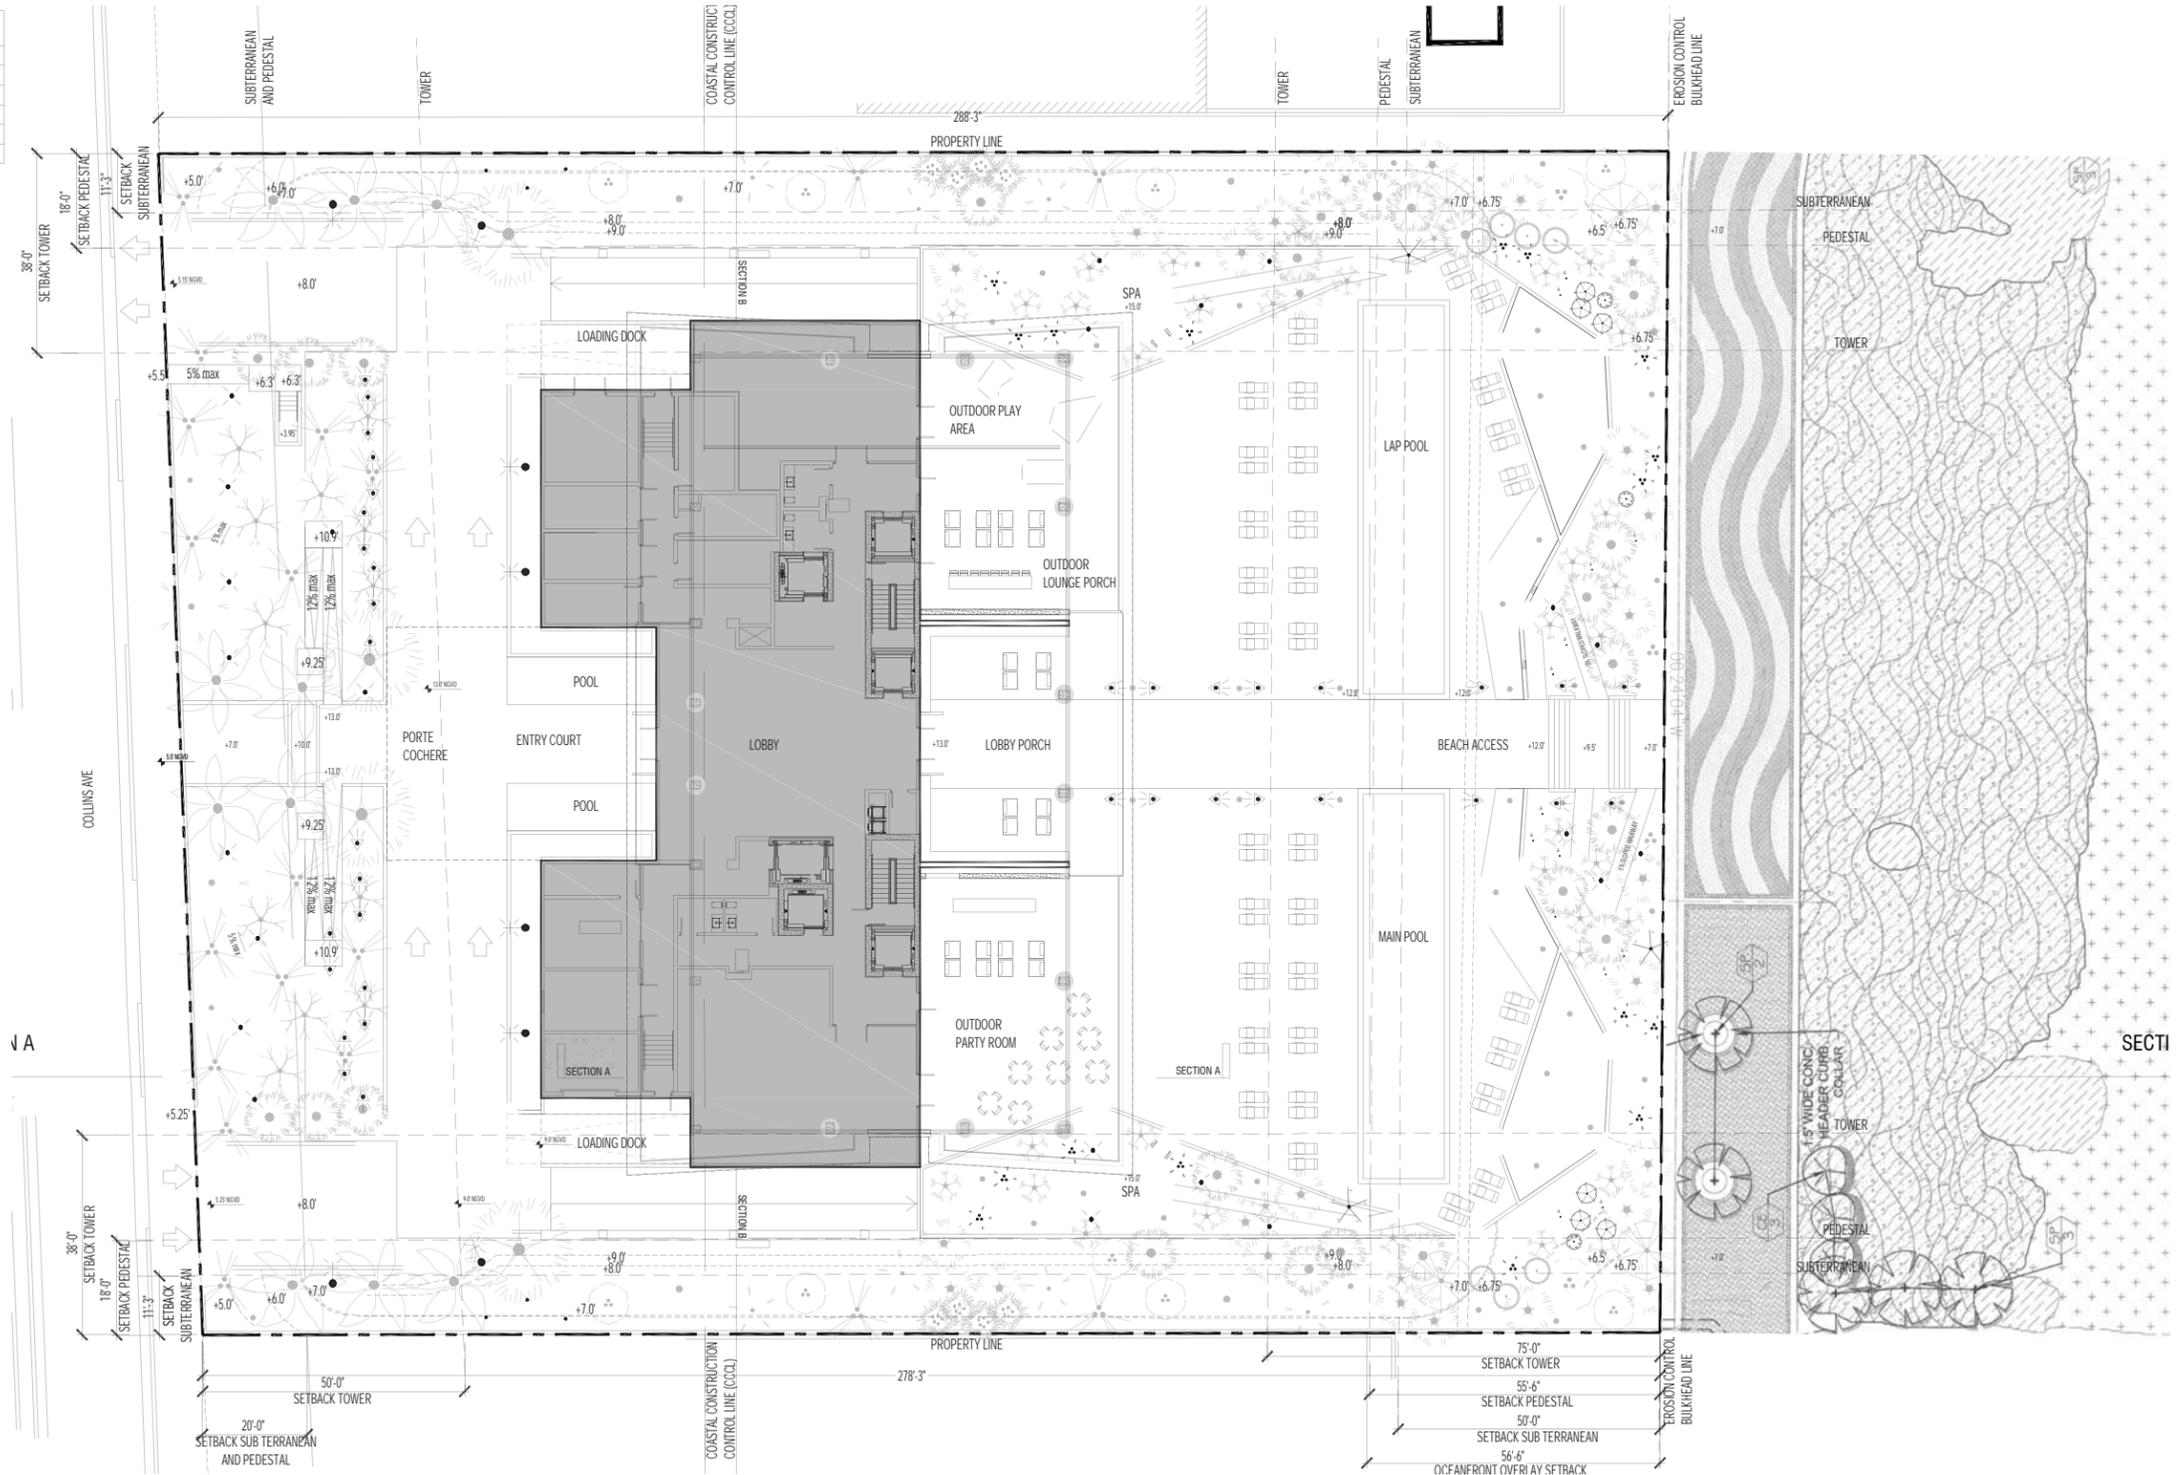

5775 COLLINS AVE

LIGHTING PLAN

2017.04.28

L1-09


MULTIPLAN

0 5 30




All designs indicated in these drawings are the property of Arquitectonica International Corp. All copyrights reserved 2017. No copies, transmissions, reproductions or electronic manipulation of any portion of these drawings in whole or in part are to be made without the express written permission of Arquitectonica International Corp. The concepts represented in these drawings are subject to review and verification by the city of Miami Beach, as well as other governmental and local agencies having jurisdiction.


ARQUITECTONICA

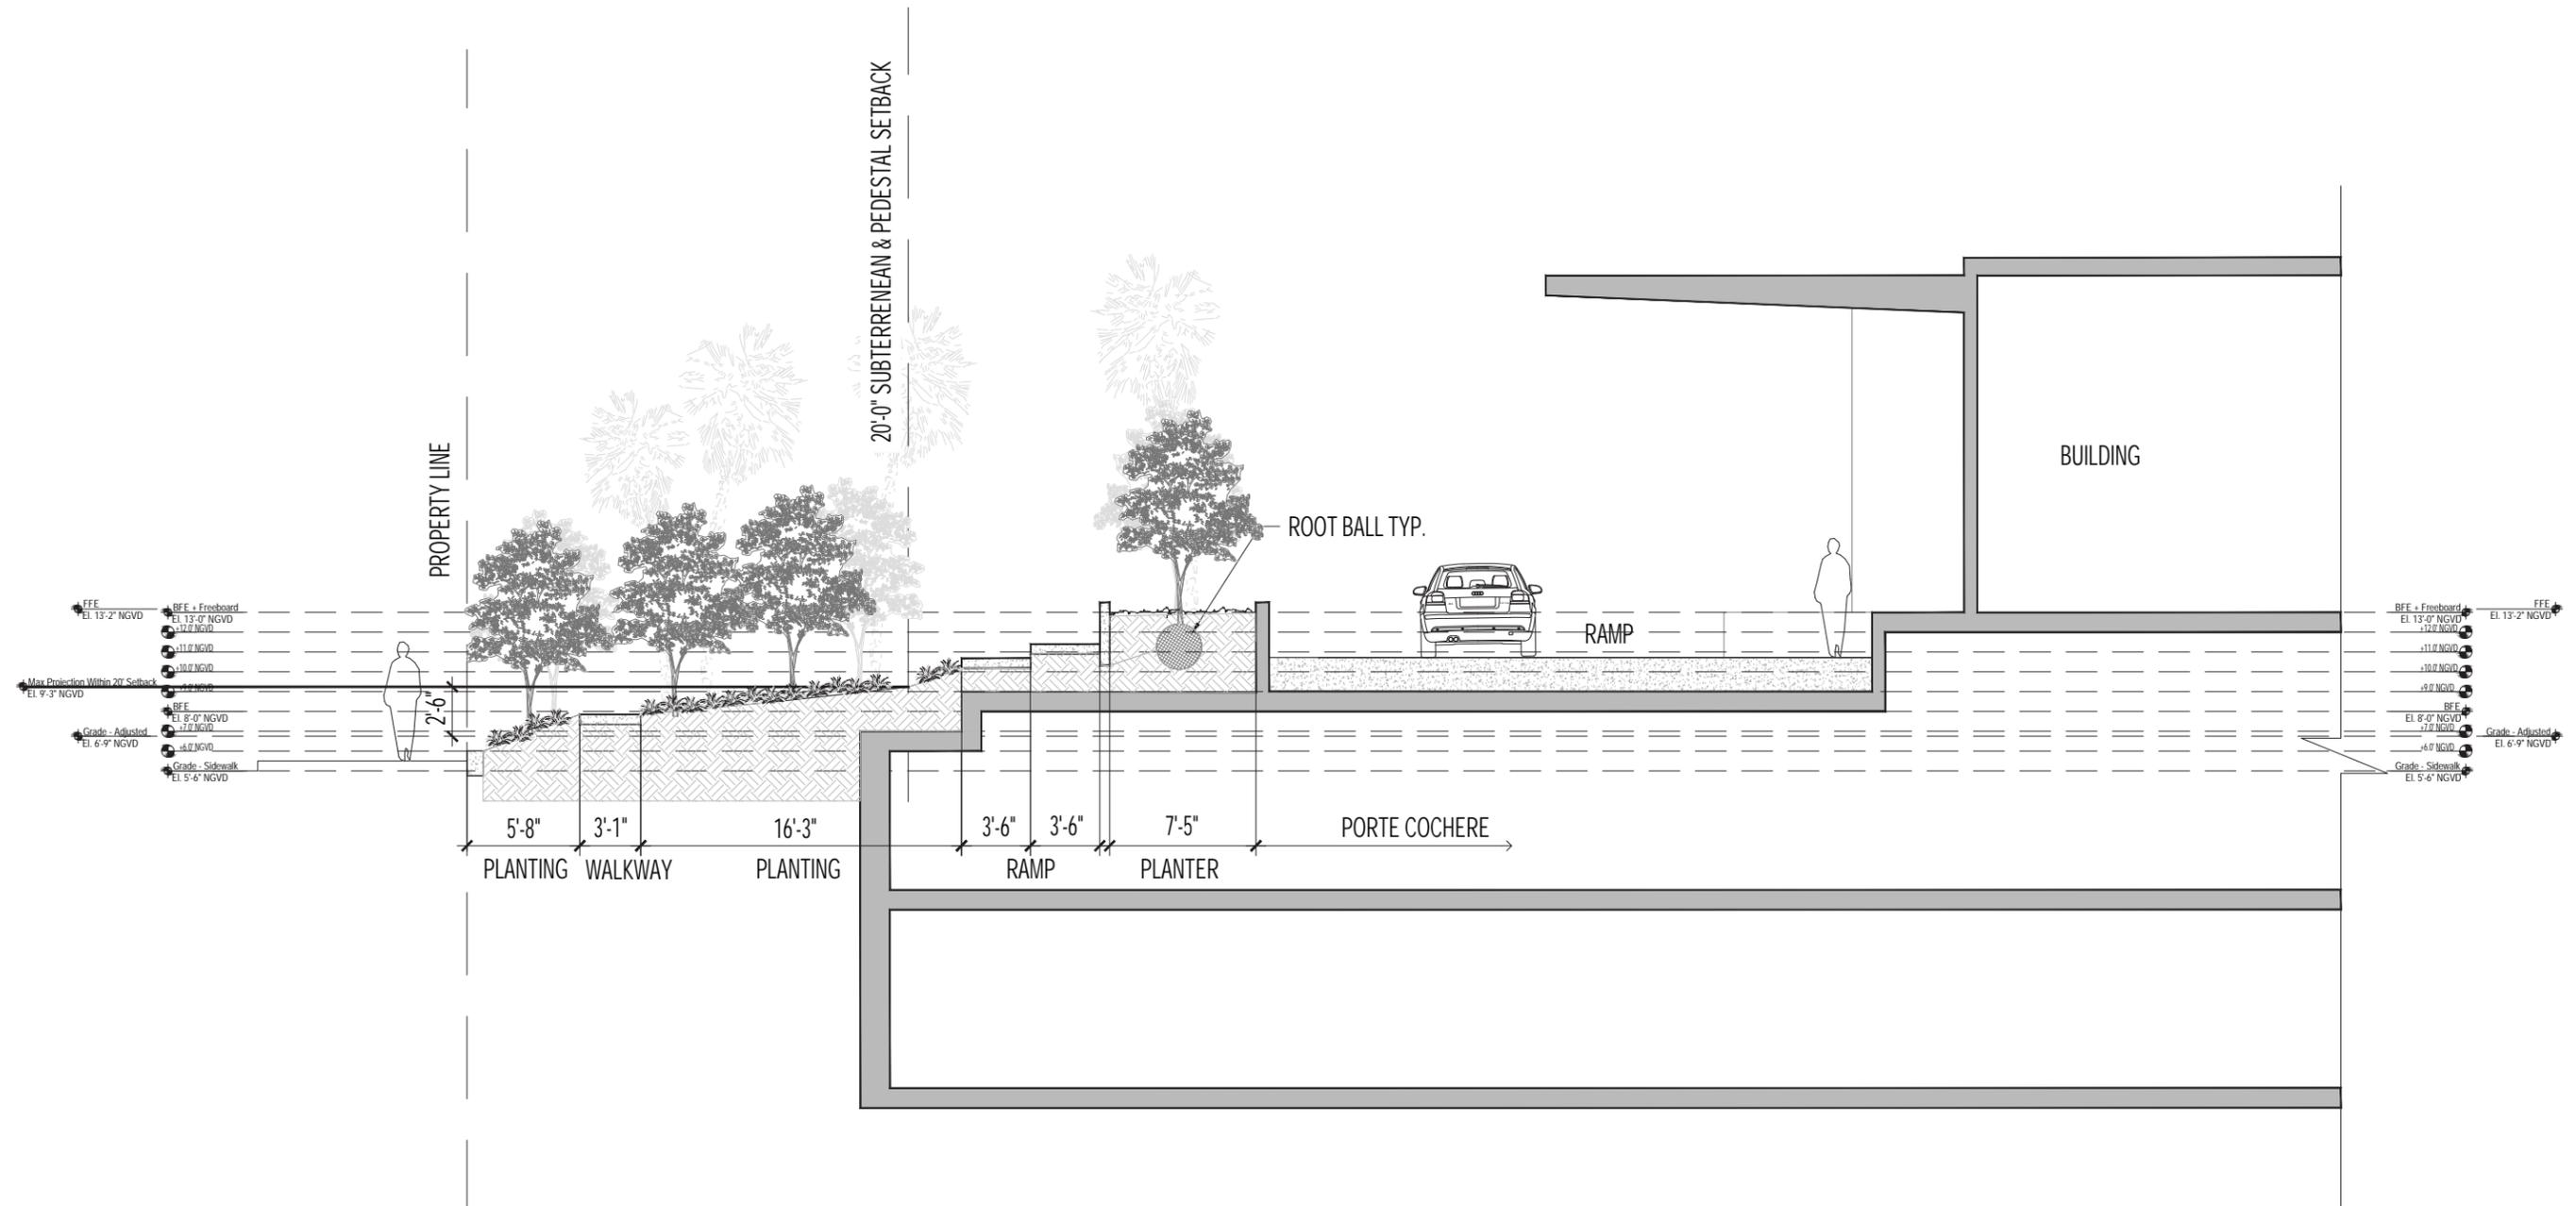


1a SITE SECTION - A
SCALE: 1/4" = 1'-0"

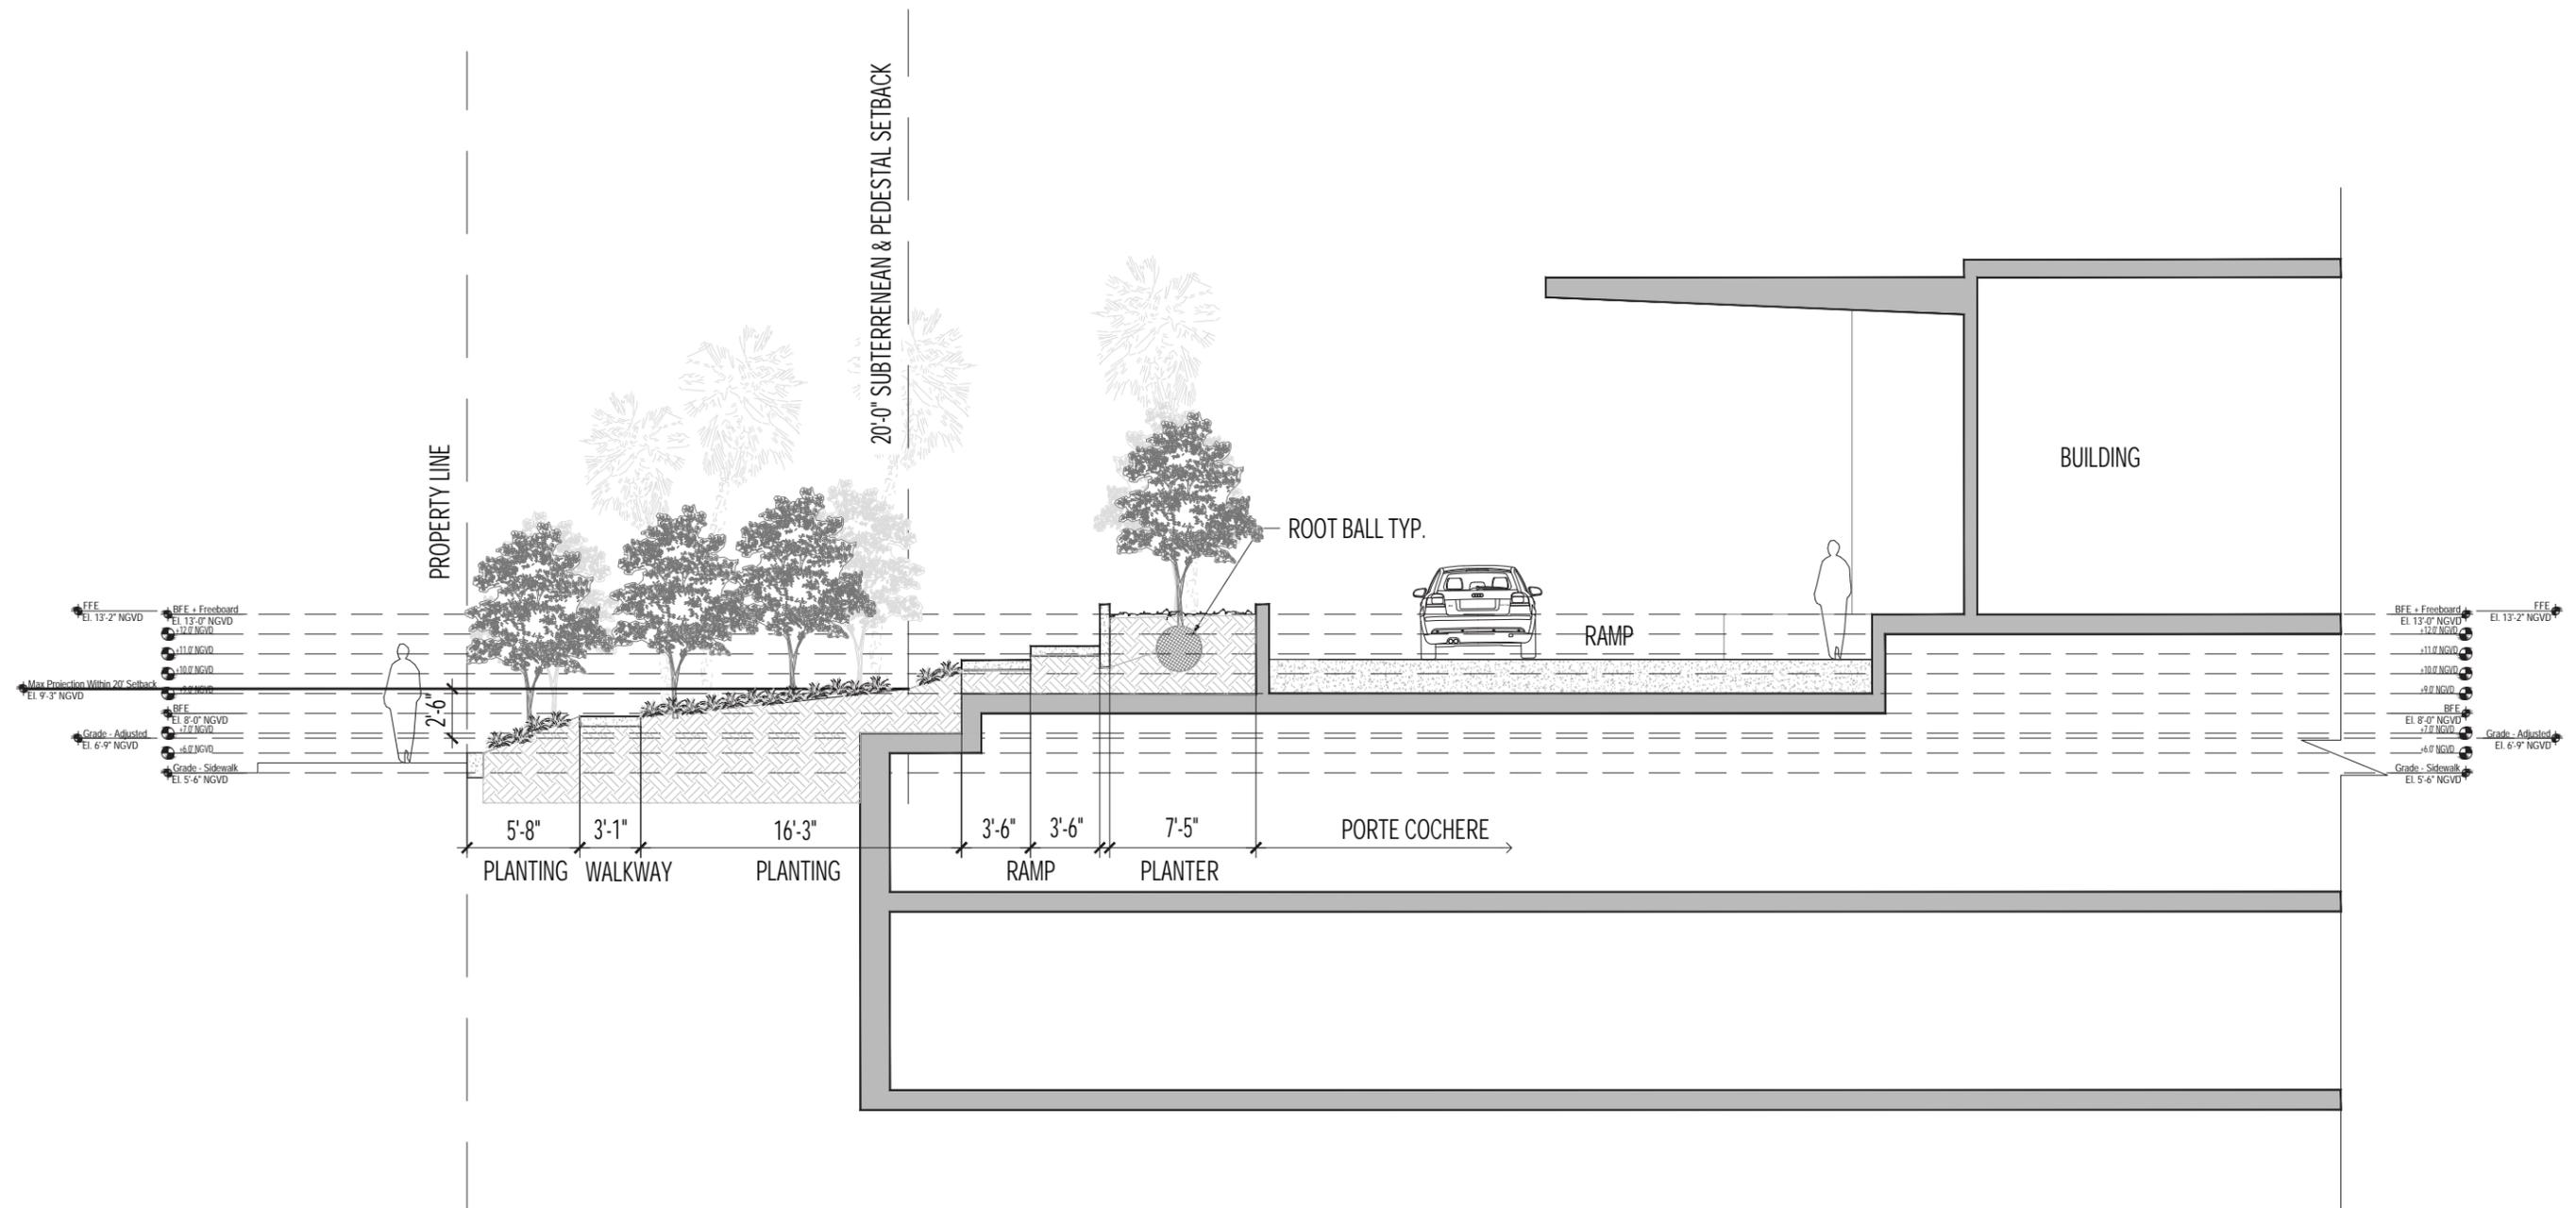


1a SITE SECTION - A
SCALE: 1/4" = 1'-0"

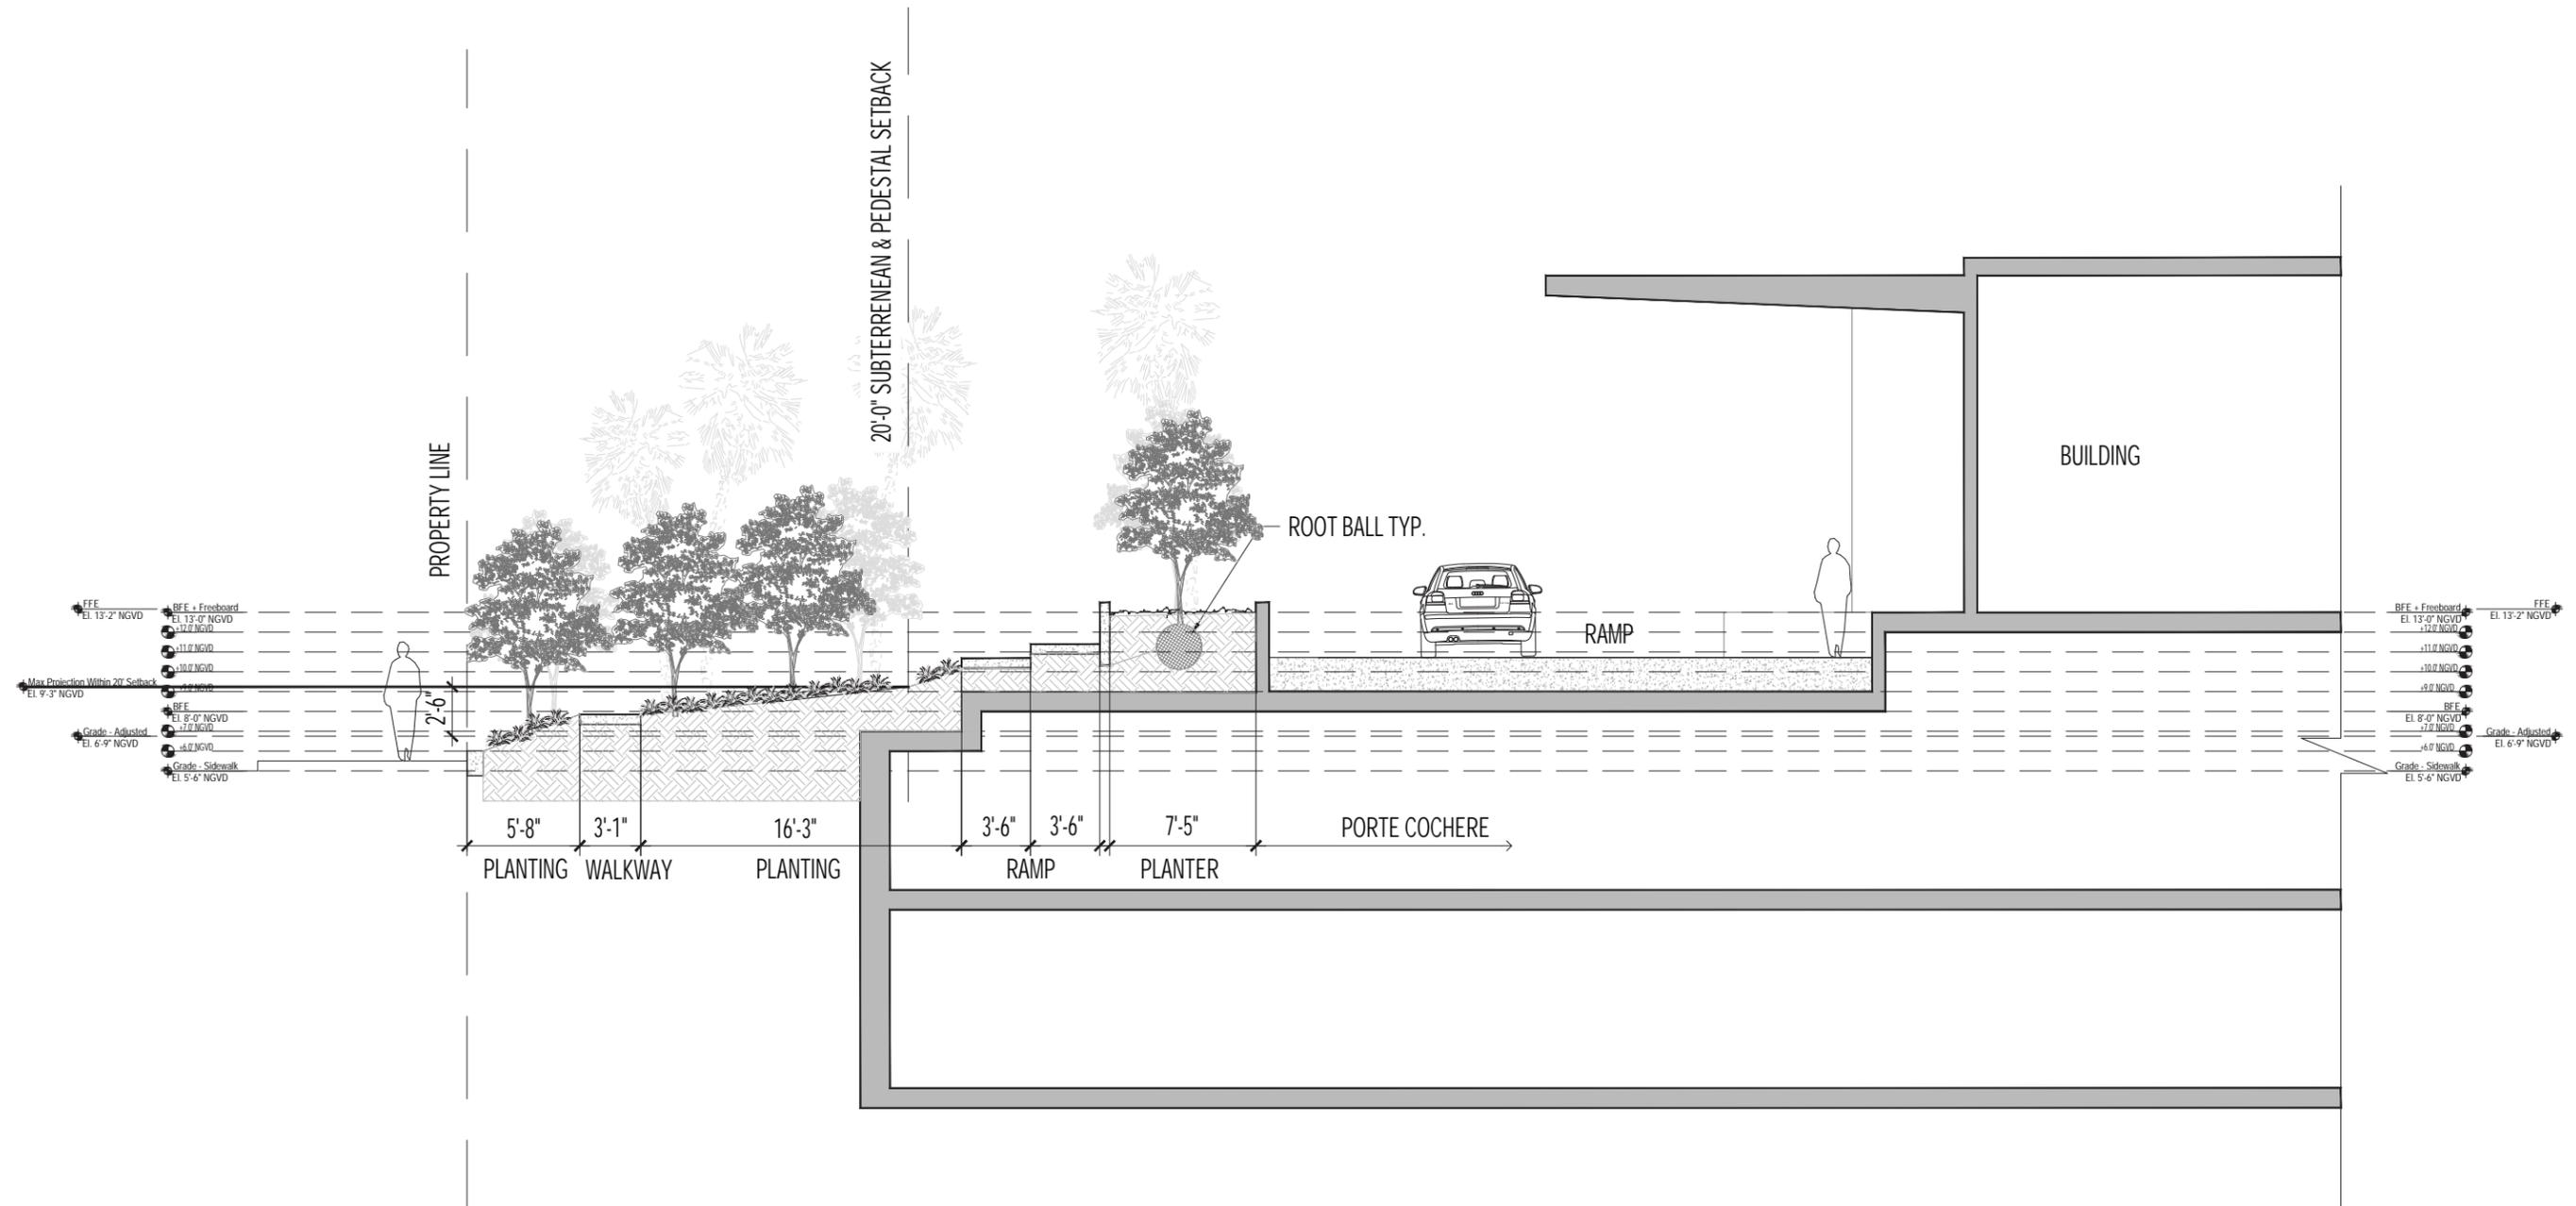


1a SITE SECTION - A
SCALE: 1/4" = 1'-0"

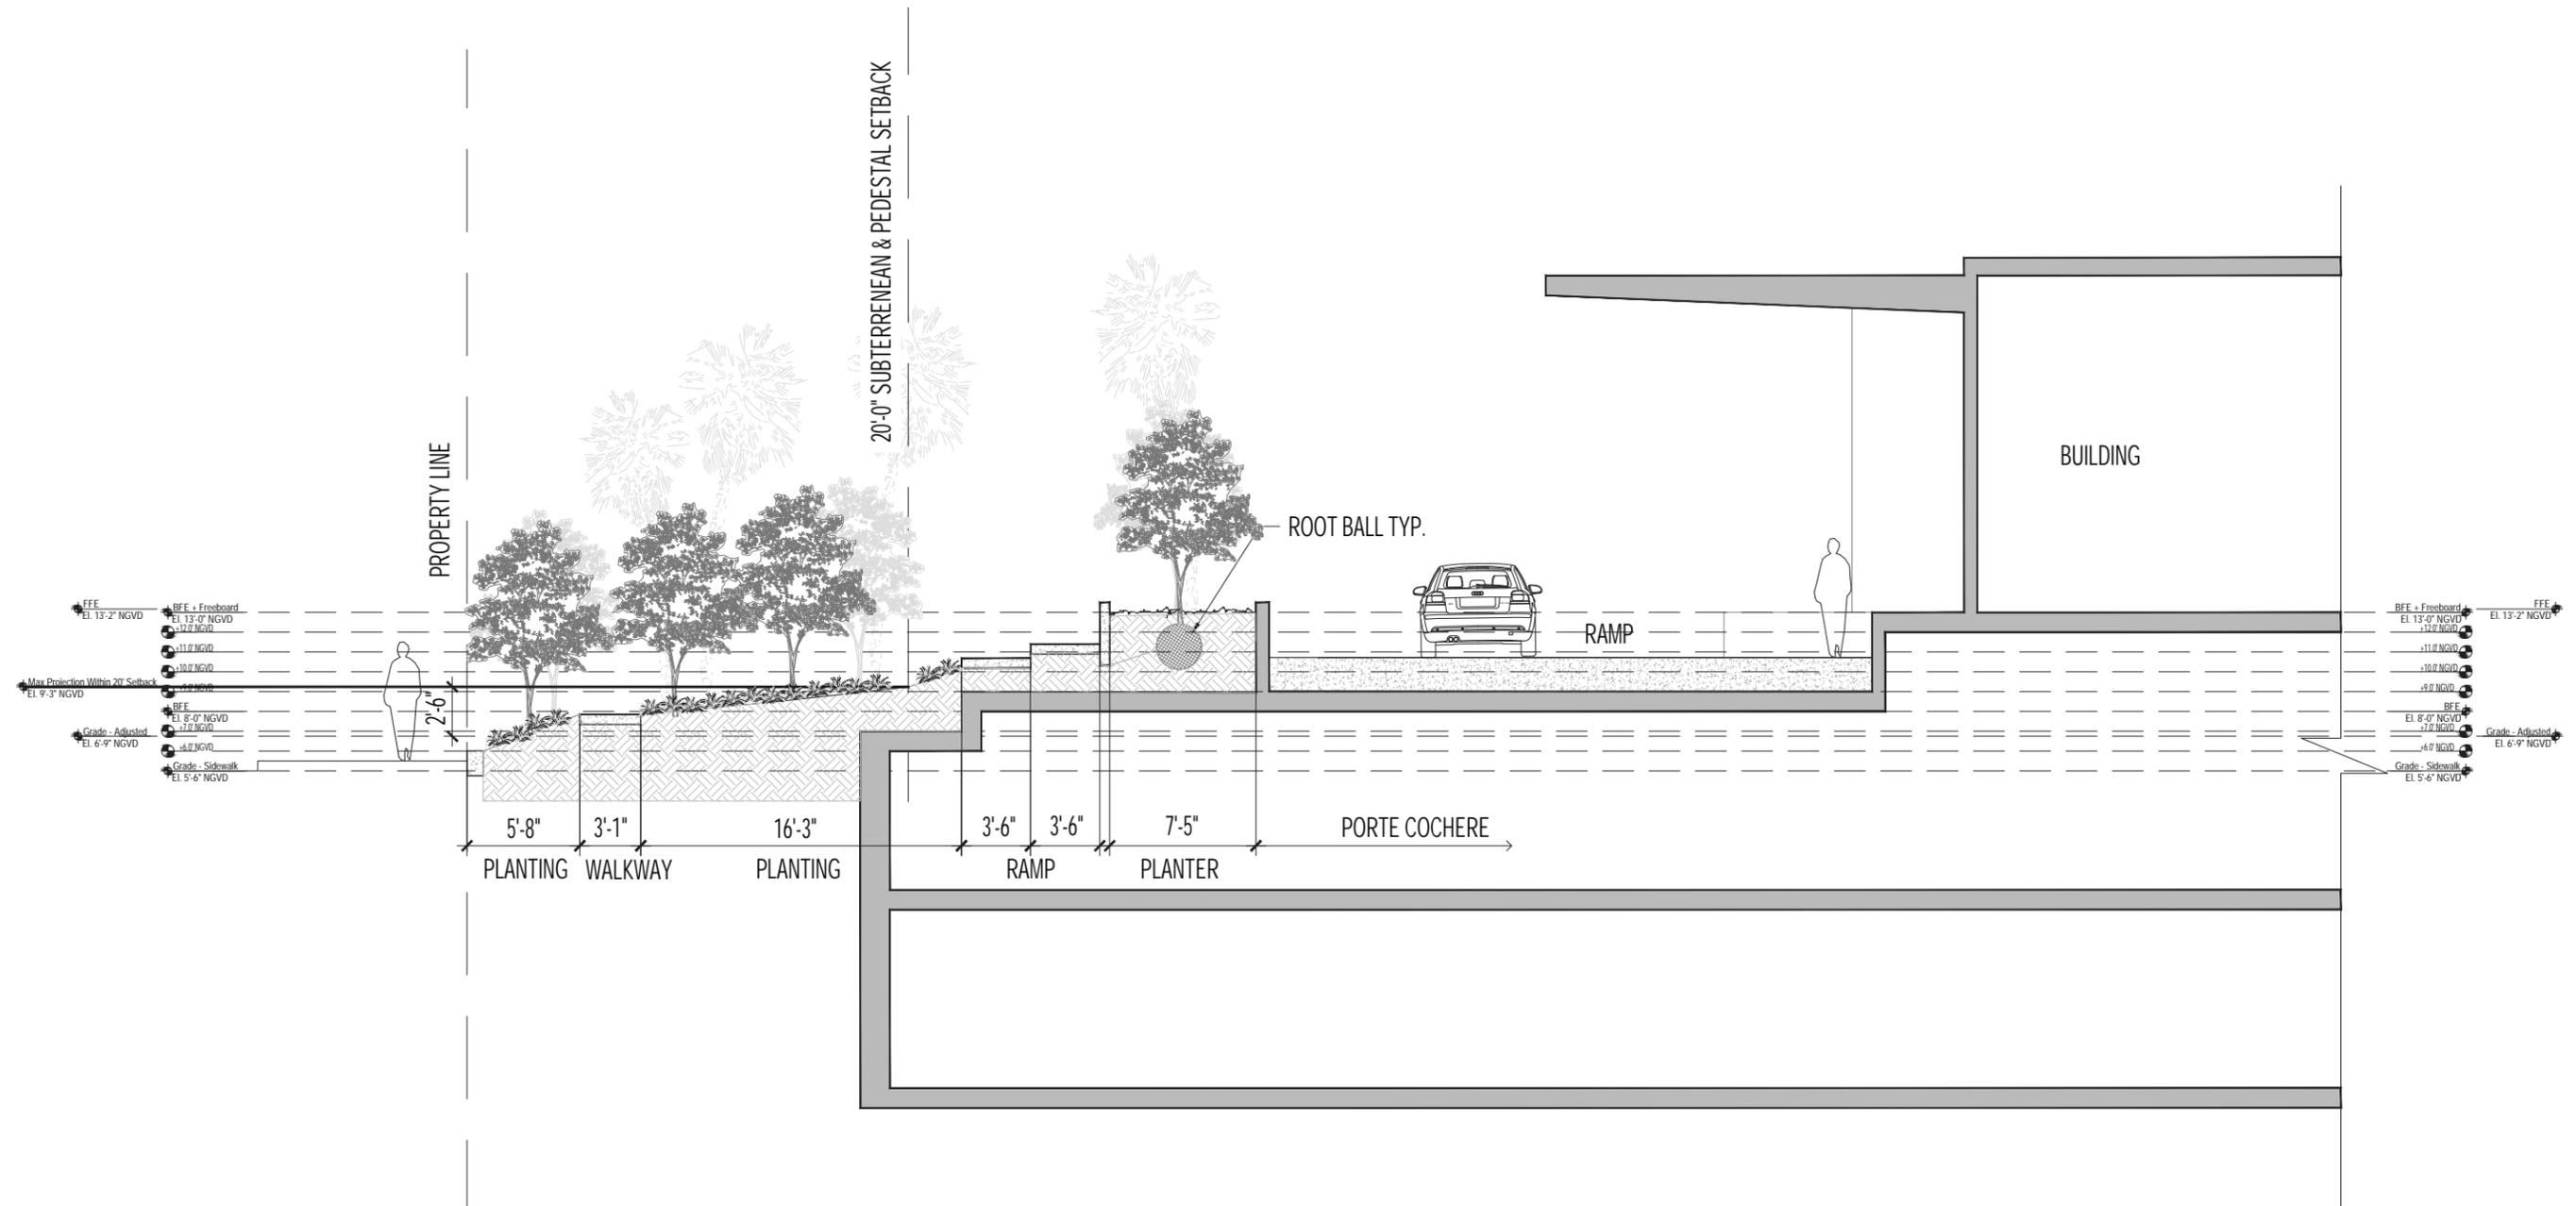


1a SITE SECTION - A
SCALE: 1/4" = 1'-0"

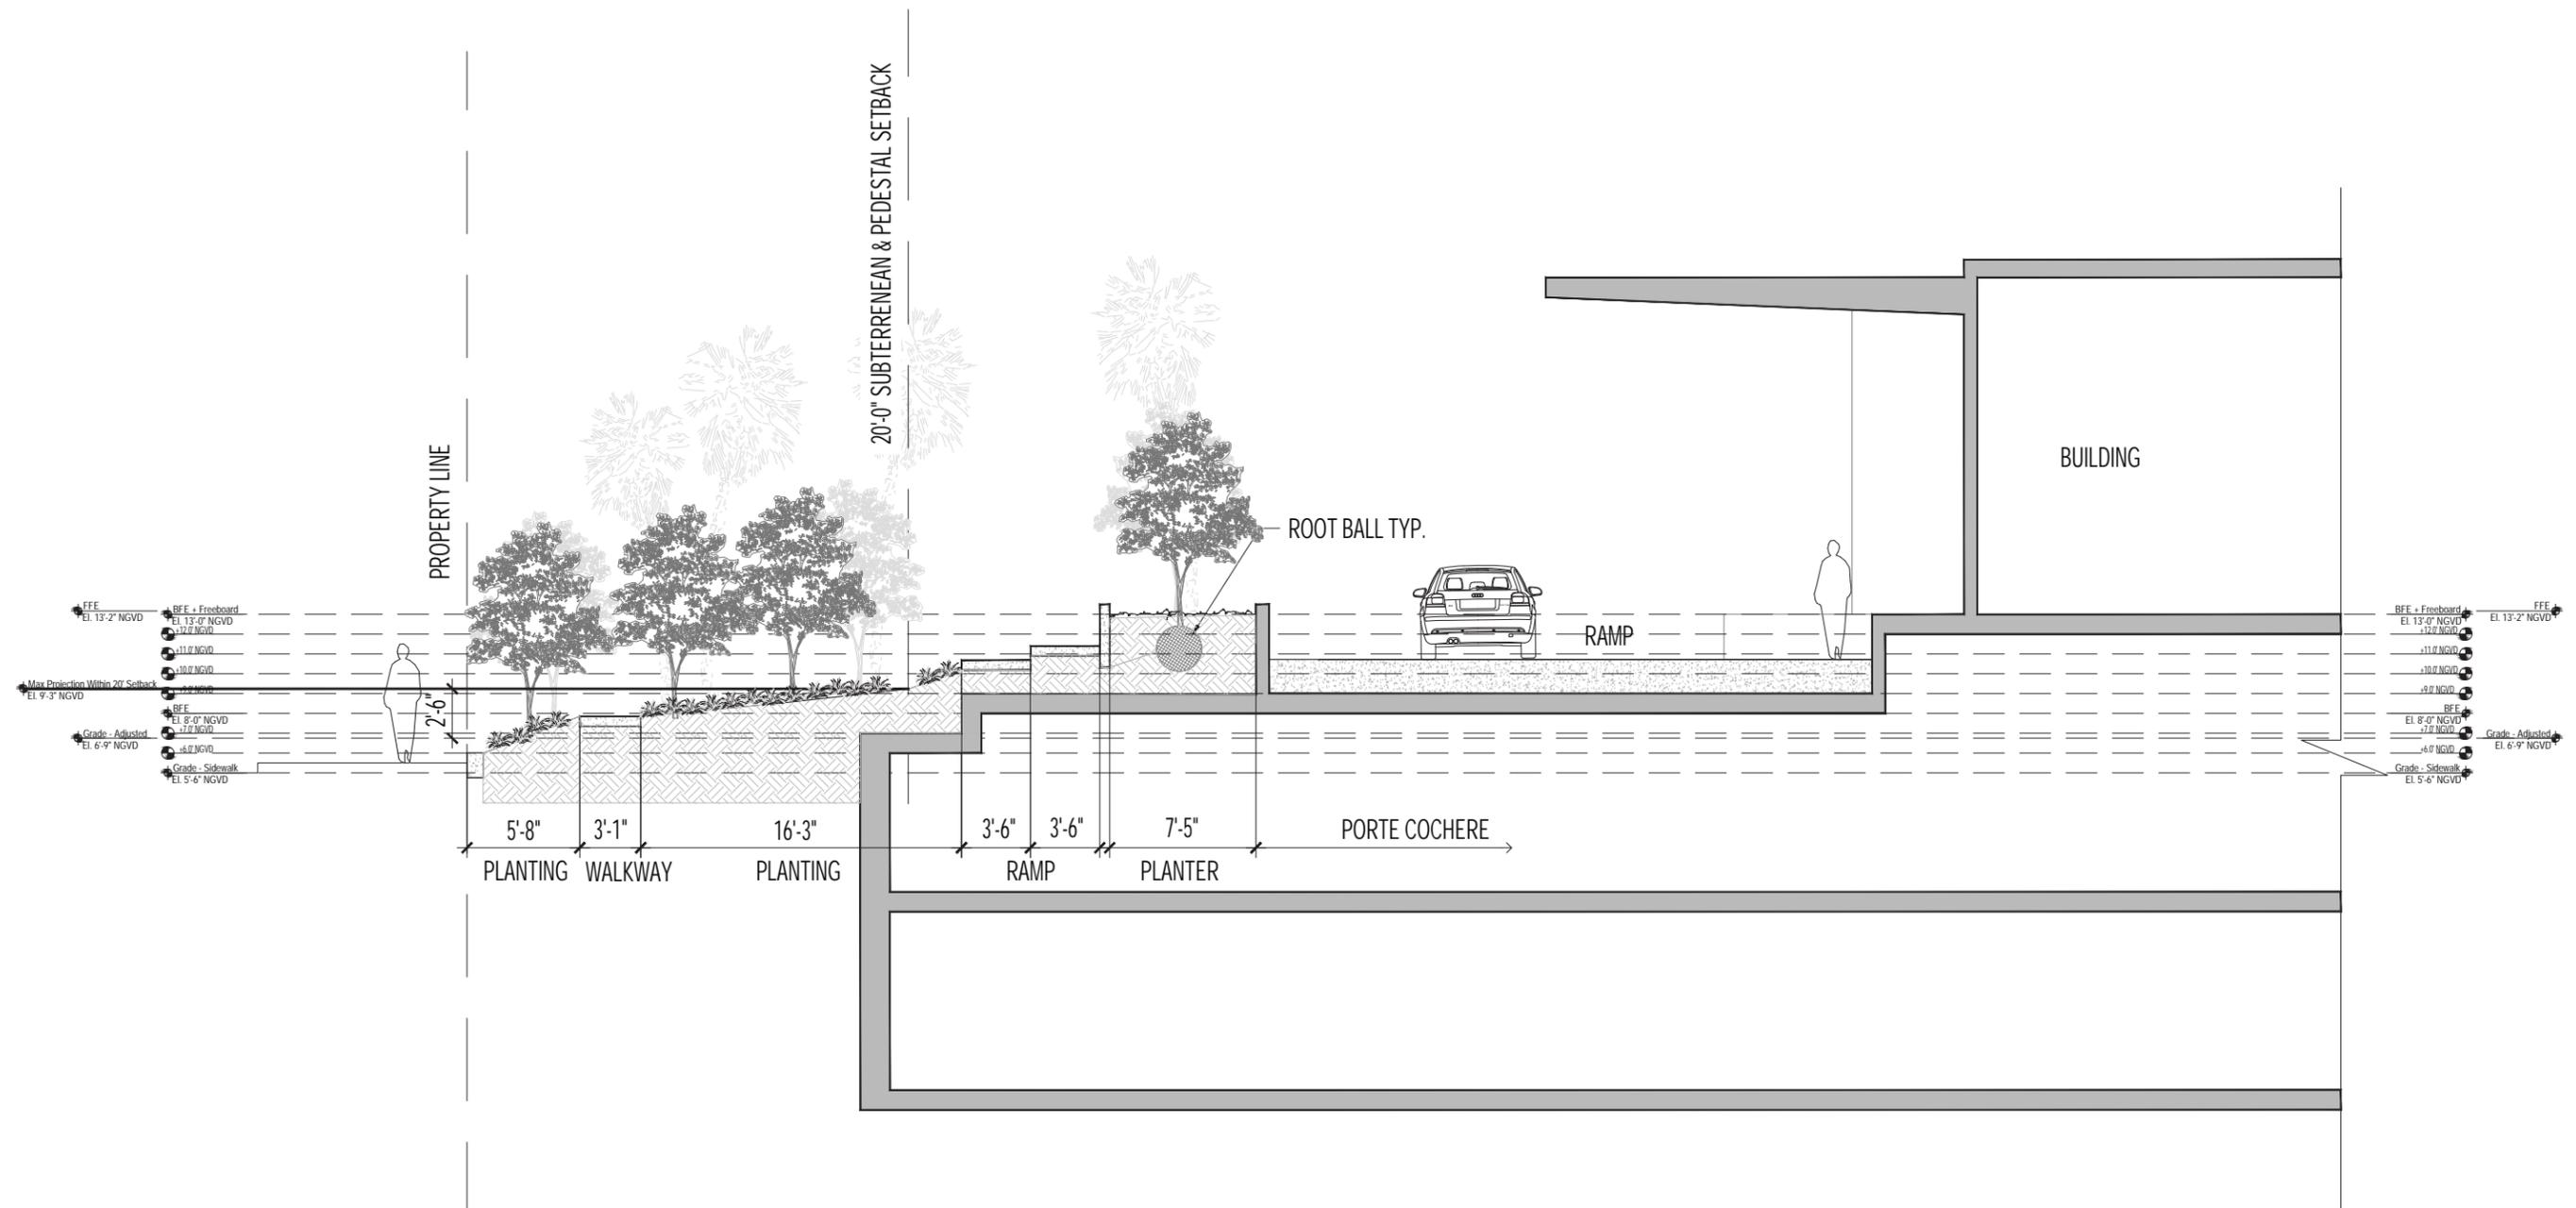


1a SITE SECTION - A
SCALE: 1/4" = 1'-0"

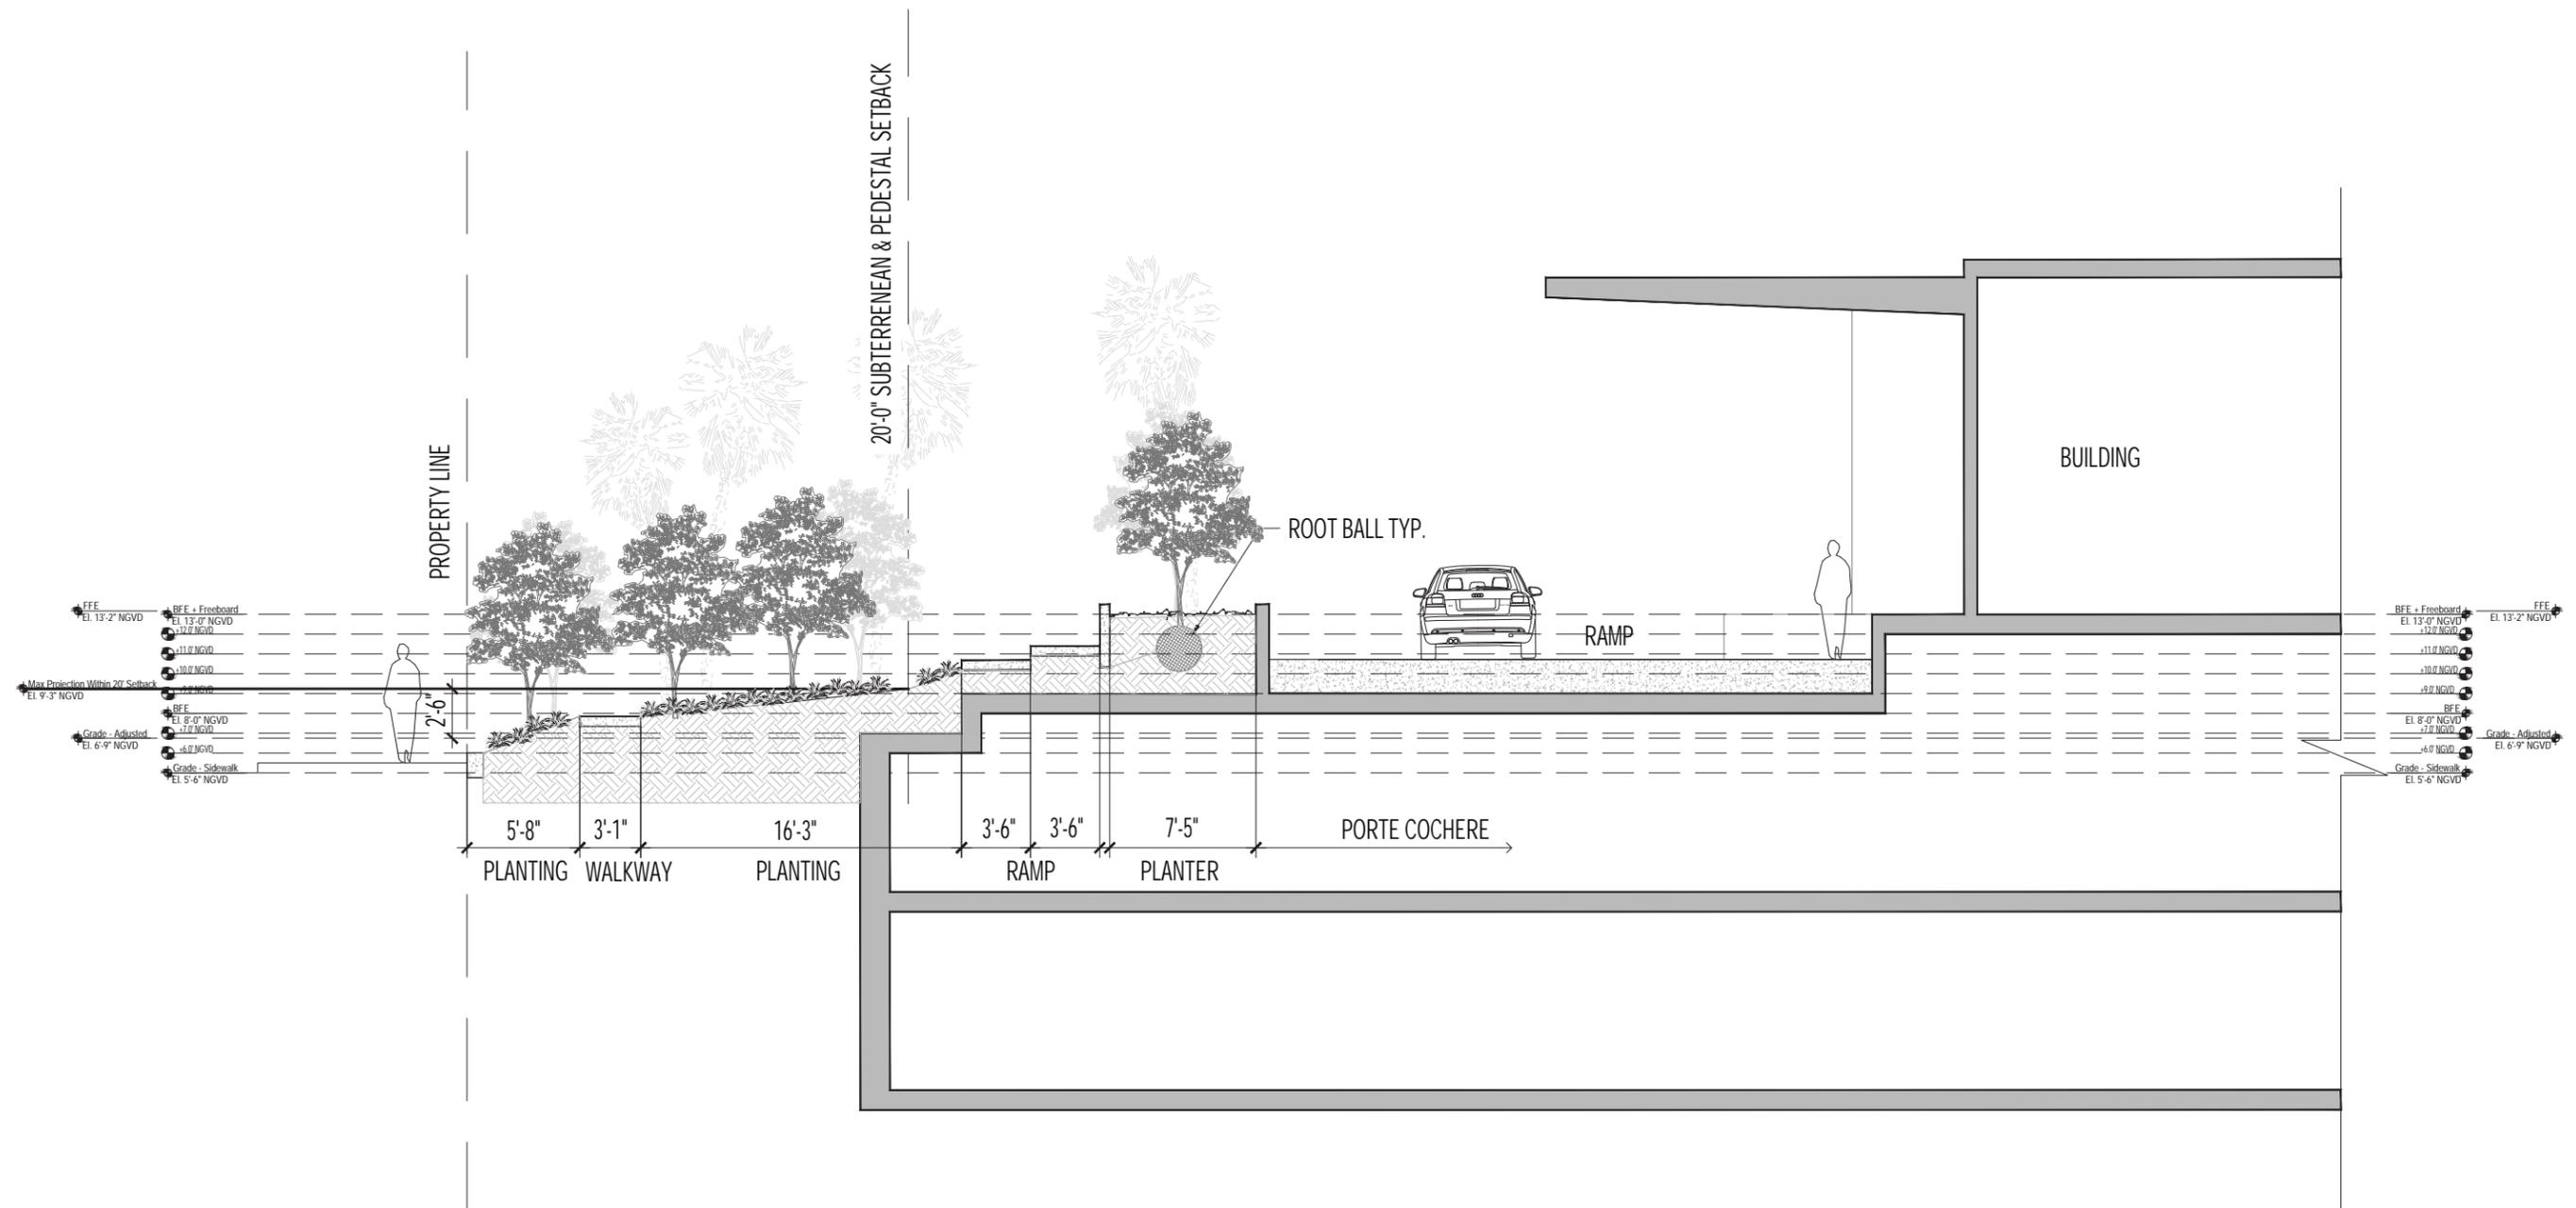


1a SITE SECTION - A
SCALE: 1/4" = 1'-0"

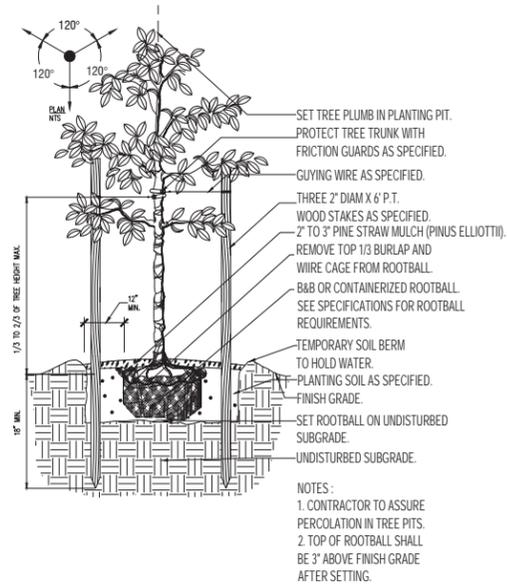


① TYP. SMALL TREE PLANTING
SCALE: 1/4" = 1'-0"

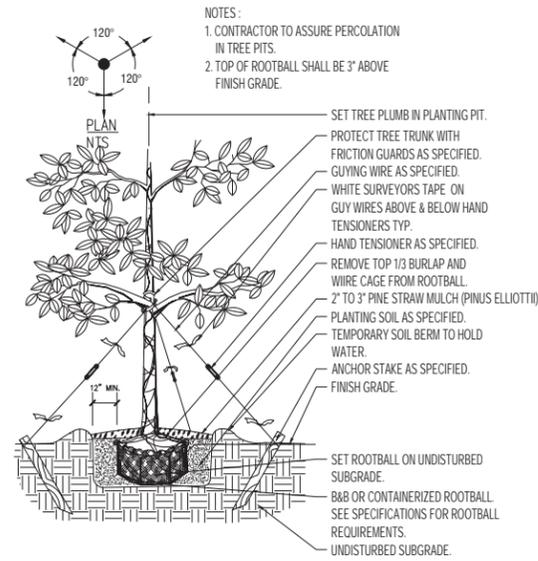

② TYP. LARGE TREE PLANTING
SCALE: 1/4" = 1'-0"

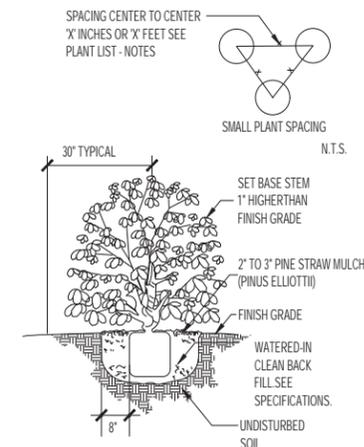

③ TYP. SHRUB & GROUNDCOVER PLANTING
SCALE: 1/2" = 1'-0"

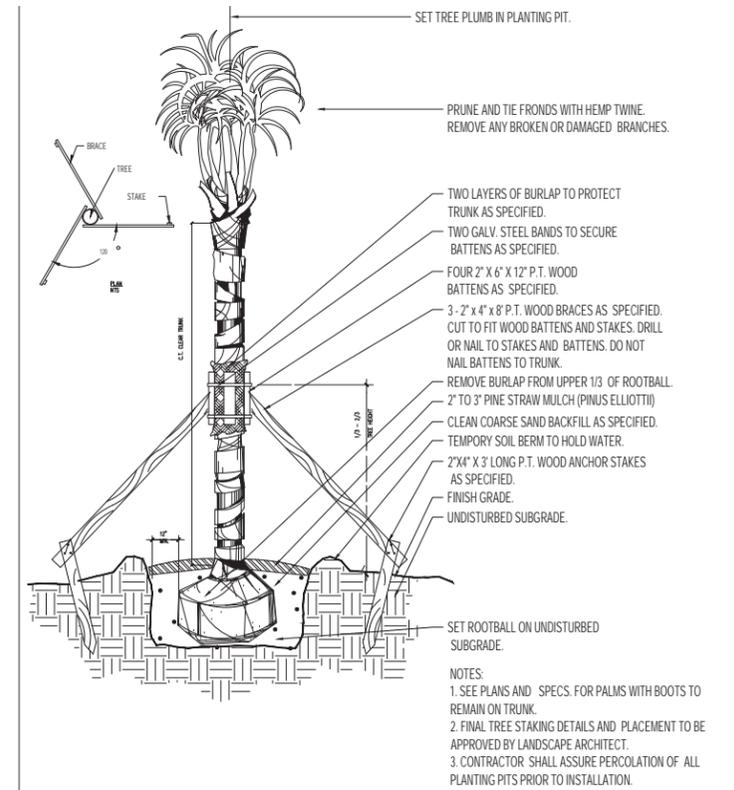

④ TYP. PALM TREE PLANTING
SCALE: 1/4" = 1'-0"